
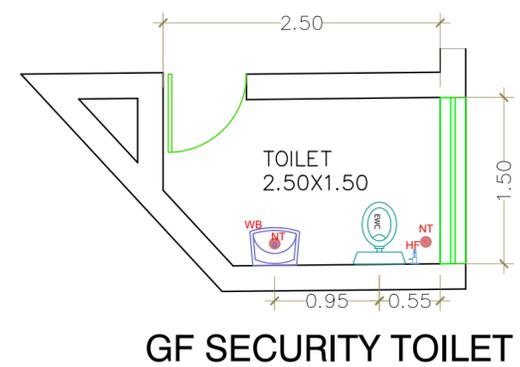
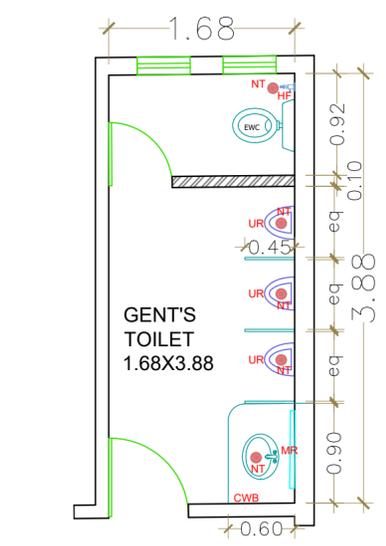


Login : ARCHITECT / Plotted on : 12/15/2025 1:59:05 PM / Document : X:\State Bank Of India\SBI - MANGALORE MAIN BRANCH\NEW\Details\Toilet Details (12.12.25).dwg

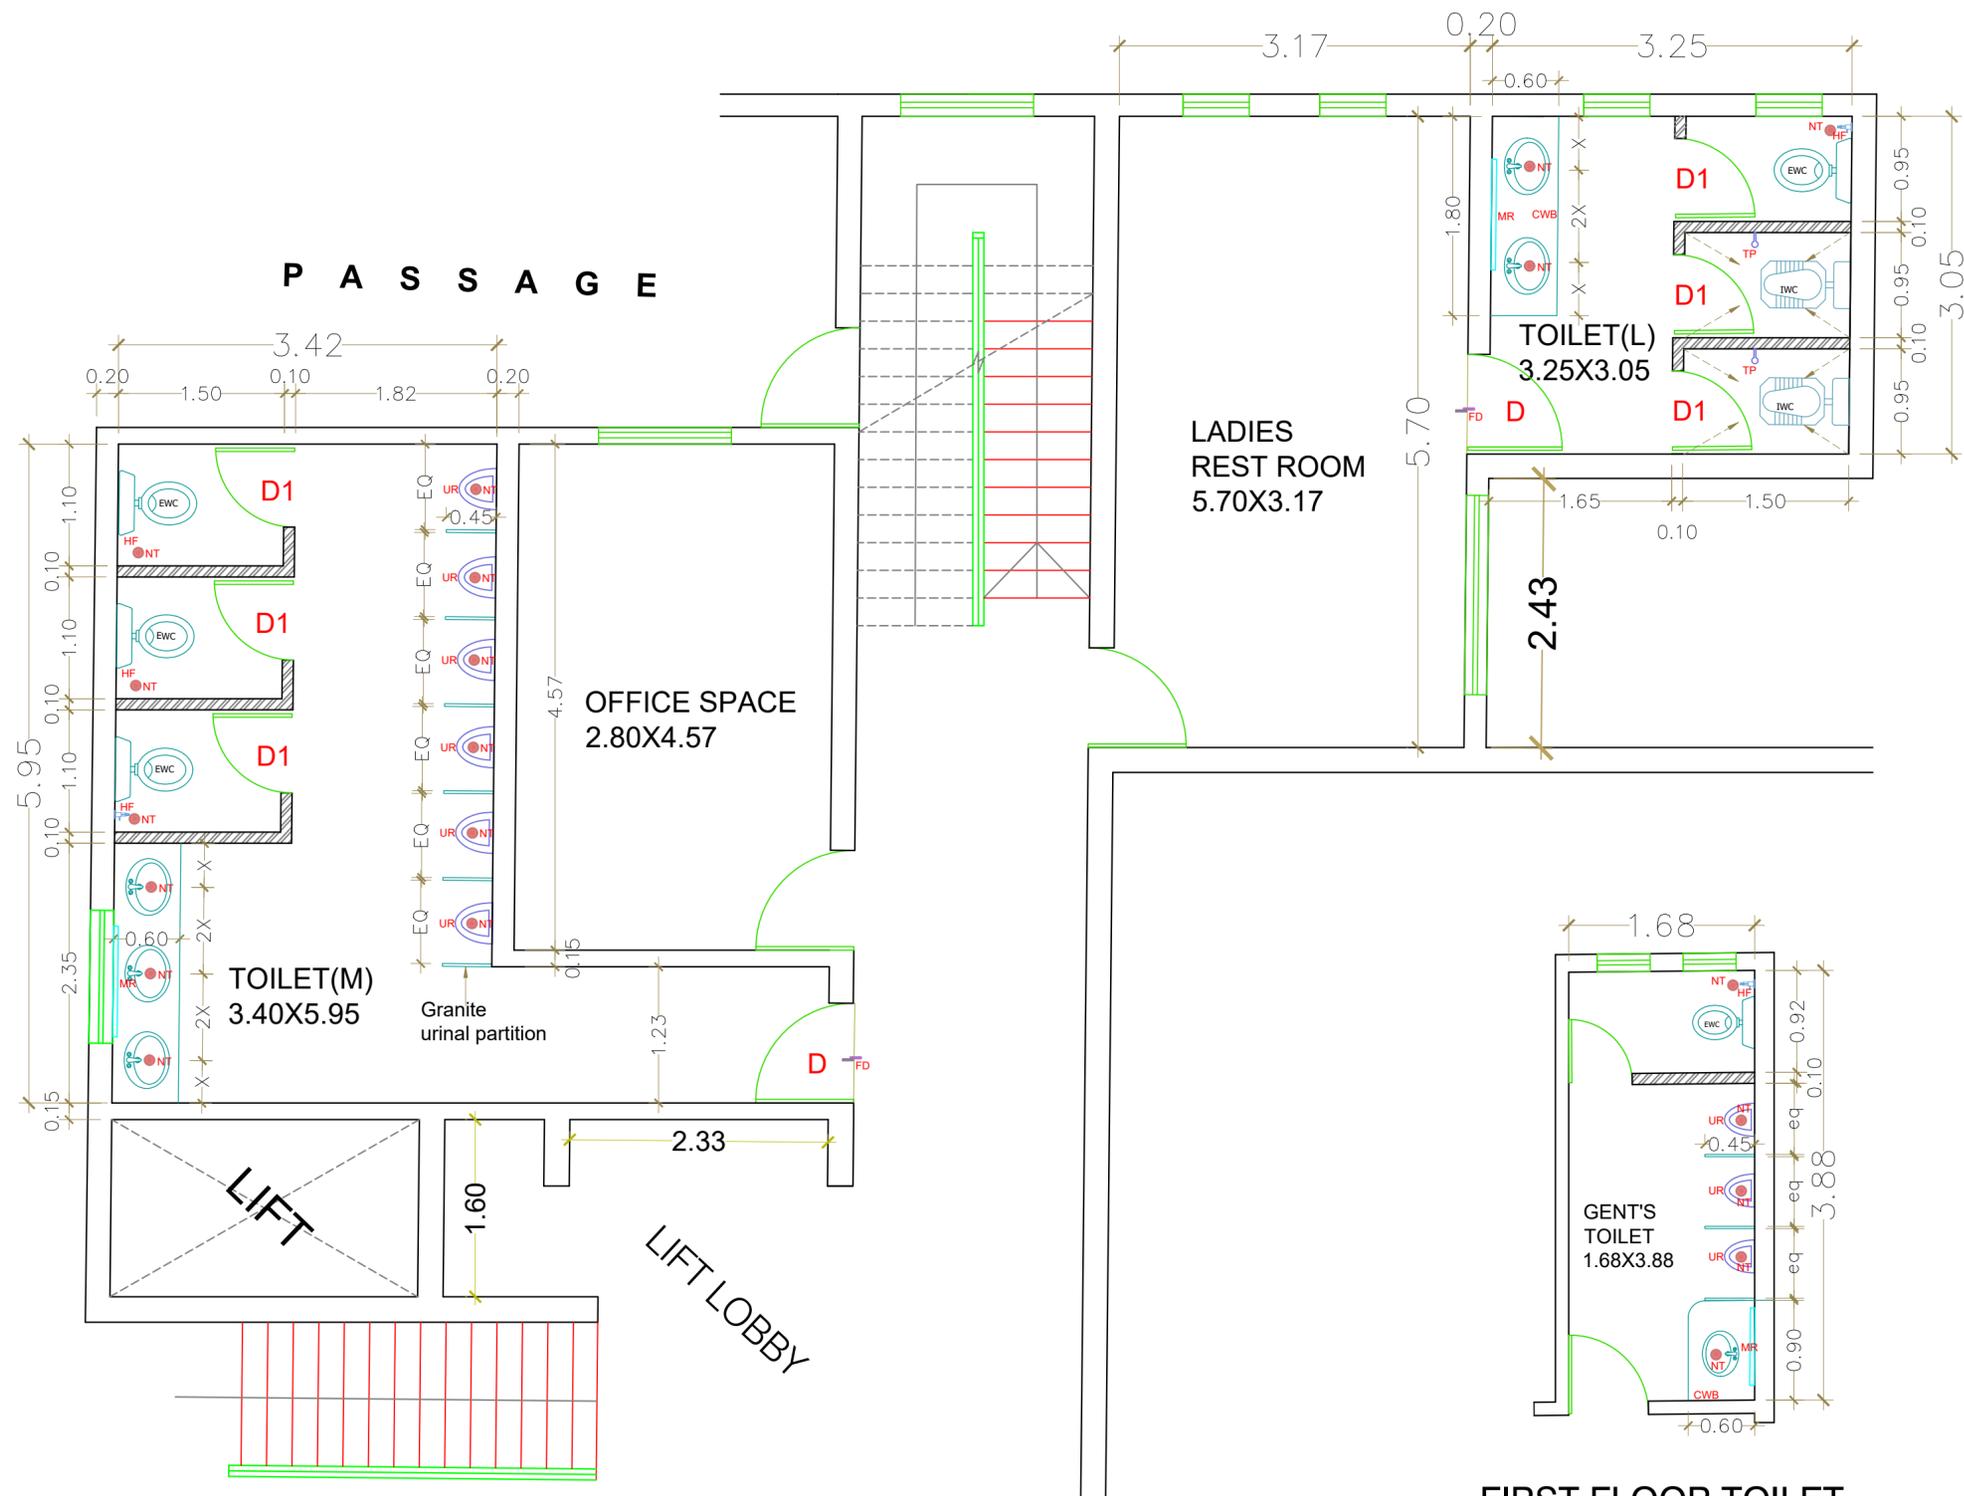

PLUMBING LEGEND	
SYM	DESCRIPTION
EWC	EUROPEAN WATER CLOSET
IWC	INDIAN WATER CLOSET
CWB	COUNTER WASH BASIN
TP	TAP
HF	HEALTH FAUCET
NT	NAHNI TRAP AT FLOOR LVL
FD	12MM FLOOR DROP
MR	MIRROR

This drawing is the sole property and copyright of VISHWANATH & ASSOCIATES and cannot be reproduced in any form without the prior consent of the architects.

**PROJECT :**  
STATE BANK OF INDIA,  
MANGALORE MAIN BRANCH

**CLIENT :**



**DRAWING TITLE :**  
TOILET DETAIL

SCALE: N T S  
DEALT: GEETHA  
CHECKED: AR  
DATE: 12 - 12 - 25

**LEGEND**

 Wall up to 2.10M HT

**SCHEDULE OF OPENING**

NO.	DESCRIPTION	DATE

**NOTE:**

REV.	REVISION DESCRIPTION	DATE
R1	=====	=====

**STATUS**  
FOR TENDOR PURPOSE

**DWG NO:**  
WD-04-TD

**ARCHITECTS**



**VISHWANATH AND ASSOCIATES**  
ARCHITECTS, ENGINEERS & INTERIOR DESIGNERS  
27, CASTLE STREET, CASTLE CHAMBERS,  
BANGALORE - 560025  
PH NO : 080 - 25573350 / 25301779  
plans@vishwanathandassociates.com