


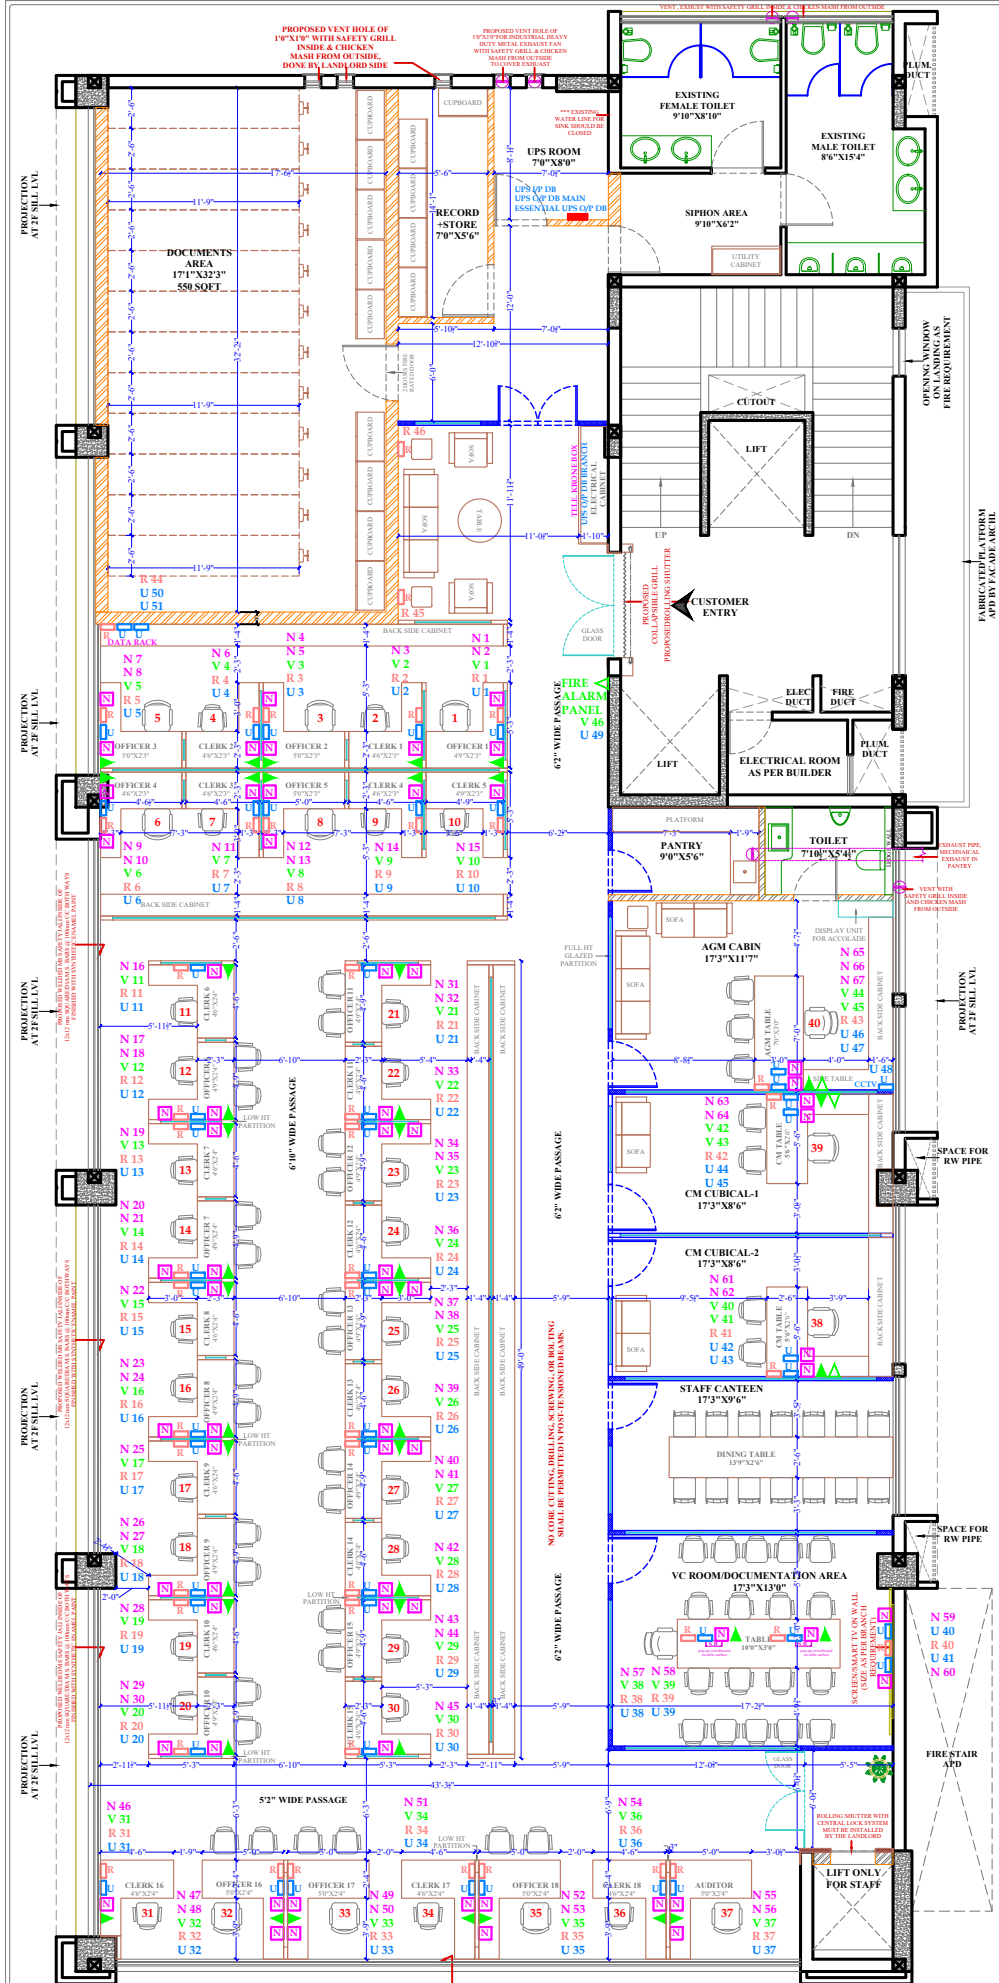

Nitin Bhardwaj
architect & interior designer

201 Gurgaon Complex, B-8 National Phase, PG, Gurgaon, Haryana
Ph: 98688 50007, Cell: 98688 50008 Email: nitin@nba.com

NETWORK LAYOUT PLAN

FOR SBI SMECC BRANCH@1F KIRTI MANDIR NEW PREMISES

SCALE: N.T.S.

DATE: 25-06-2026

DRAWN BY: NETTI

REVISION NO: 03

- ESSENTIAL DB: FOLLOWING POINTS TO BE CONSIDERED.**
- 1) For data rack - two ups points should be laid from diff. ups units for continuous power supply of data rack.
 - 2) ONE SEPARATE UPS CIRCUIT SHOULD BE LAID IN AGM CABIN FOR CCTV
 - 3) 6 A. S. PLUG UPS SUPPLY FOR FIRE ALARM SYSTEM & ONE TELE. POINT.

N - SYMBOL FOR DATA I/O POINT.
V - SYMBOL FOR TELE. I/O POINT.
R - SYMBOL FOR RAW POWER POINT.
U - SYMBOL FOR UPS POWER POINT.

LEGEND-BACKUPPOWER

- R 2 NOS. 6 A. SOCKET WITH ONE NO. 6 A. SWITCH.
- U 2 NOS. 6 A. SOCKET + ONE NO. 16 A. SOCKET WITH ONE NO. 16 AMP. SWITCH WITH INDICATOR.
- DB UPS DB - 1/P DB & Q/P DB.

LEGEND-NETWORK

- N COMPUTER DATA I/O NODE.
- V INTERCOM TELE. RJ 11 JACK POINT.
- R DIRECT TELE. RJ 11 JACK POINT.
- A IP TELE. RJ 45 JACK POINT.
- F FAX TELE. RJ 11 JACK POINT.